


**CONSTRUCTION PLANS OF RECORD**  
 THESE RECORD DOCUMENTS HAVE BEEN PREPARED BASED ON THE BEST AVAILABLE INFORMATION PROVIDED BY OTHERS. THE DESIGN PROFESSIONAL HAS NOT VERIFIED THE ACCURACY AND/OR COMPLETENESS OF THIS INFORMATION AND SHALL NOT BE RESPONSIBLE FOR ANY ERRORS OR OMISSIONS WHICH MAY BE INCORPORATED HEREIN AS A RESULT.

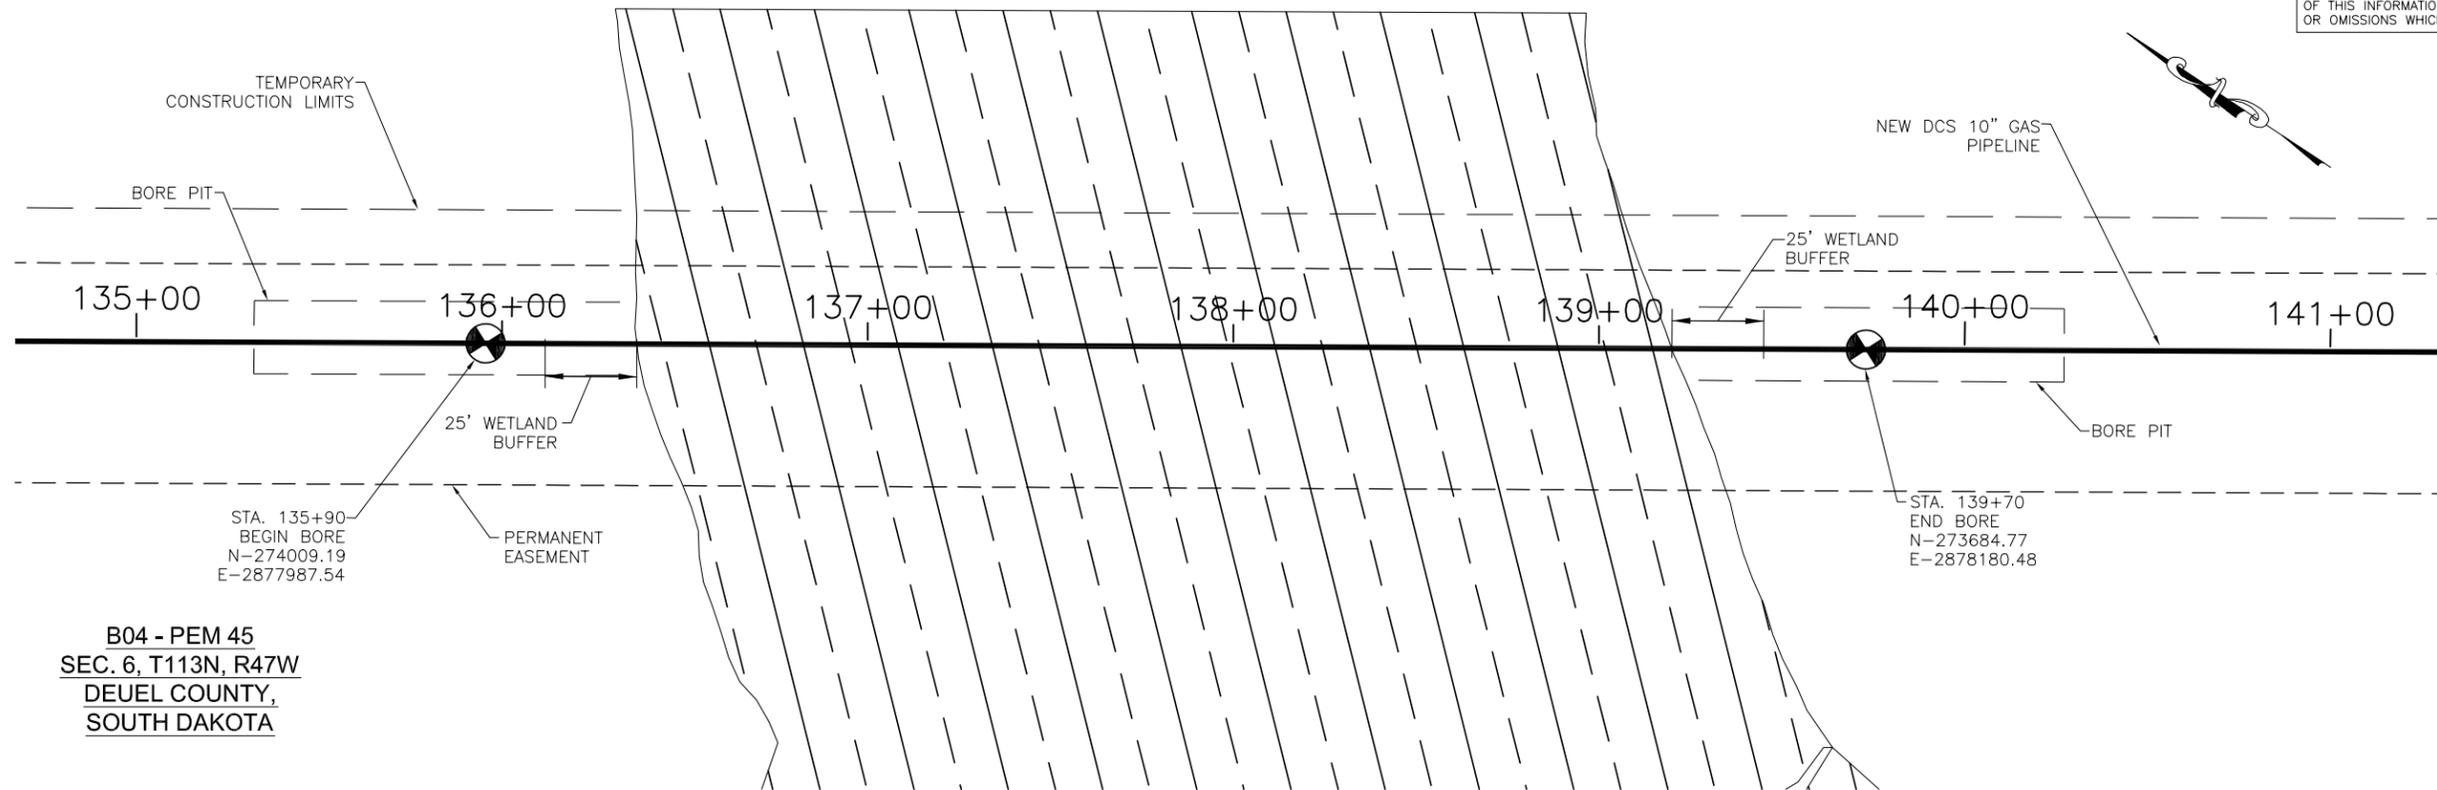

**B04 - PEM 45**  
**SEC. 6, T113N, R47W**  
**DEUEL COUNTY,**  
**SOUTH DAKOTA**

STA. 135+90  
 BEGIN BORE  
 N=274009.19  
 E=2877987.54

STA. 139+70  
 END BORE  
 N=273684.77  
 E=2878180.48

**NOTE:**  
 BEARINGS AND DISTANCES ARE BASED ON THE SOUTH DAKOTA STATE PLANE COORDINATE SYSTEM, NORTH ZONE - NAD83 (US SURVEY FEET)

LAND DIMENSION INFORMATION FOR THIS EXHIBIT WAS DERIVED FROM LAND SURVEY DATA.


ALL UNDERGROUND UTILITIES ARE SHOWN IN GENERAL LOCATION. CONTRACTOR TO FIELD VERIFY PRIOR TO CONSTRUCTION.

SEE PLAN AND PROFILE SHEETS FOR LEGEND.



SCALE IN FEET

**BANNER**  
 Engineering | Architecture | Surveying  
 409 22nd Avenue S. | PO Box 298  
 Brookings, South Dakota 57006  
 605.692.6342  
 www.bannerassociates.com  
 Designing Projects | Building Trust

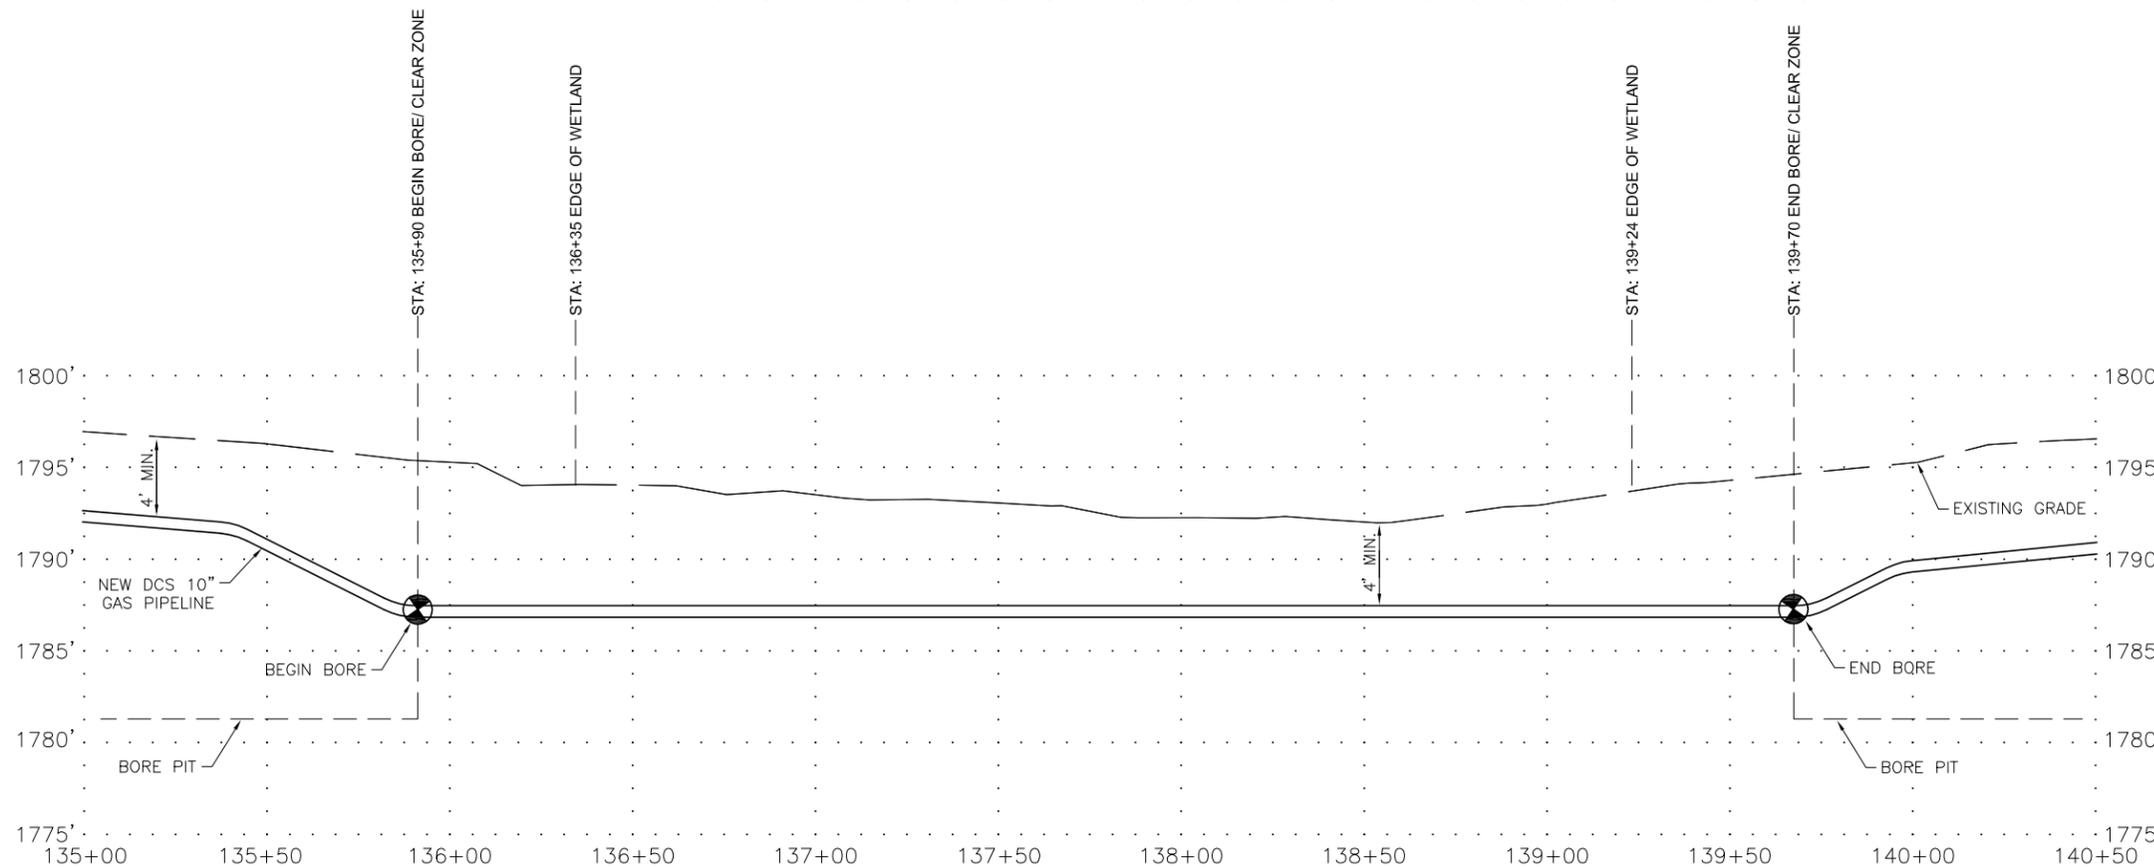

REVISIONS	
NO.	DATE

**BASIN ELECTRIC**  
**POWER COOPERATIVE**  
 A Touchstone Energy® Cooperative

**MONTANA-DAKOTA**  
**UTILITIES CO.**  
 A Division of MDU Resources Group, Inc.

DEER CREEK STATION GAS PIPELINE  
 DEUEL & BROOKINGS COUNTY, SOUTH DAKOTA  
 DCS-CD-ONG-0003

DRAWN BY: AME	CHECK BY: SDR
SIGNED BY: DPY	ENGINEER
DATE: JANUARY 2011	
GAS PIPELINE BORING - B04 AT WETLAND	
DCS-B03	