



Mainline Valve Typical

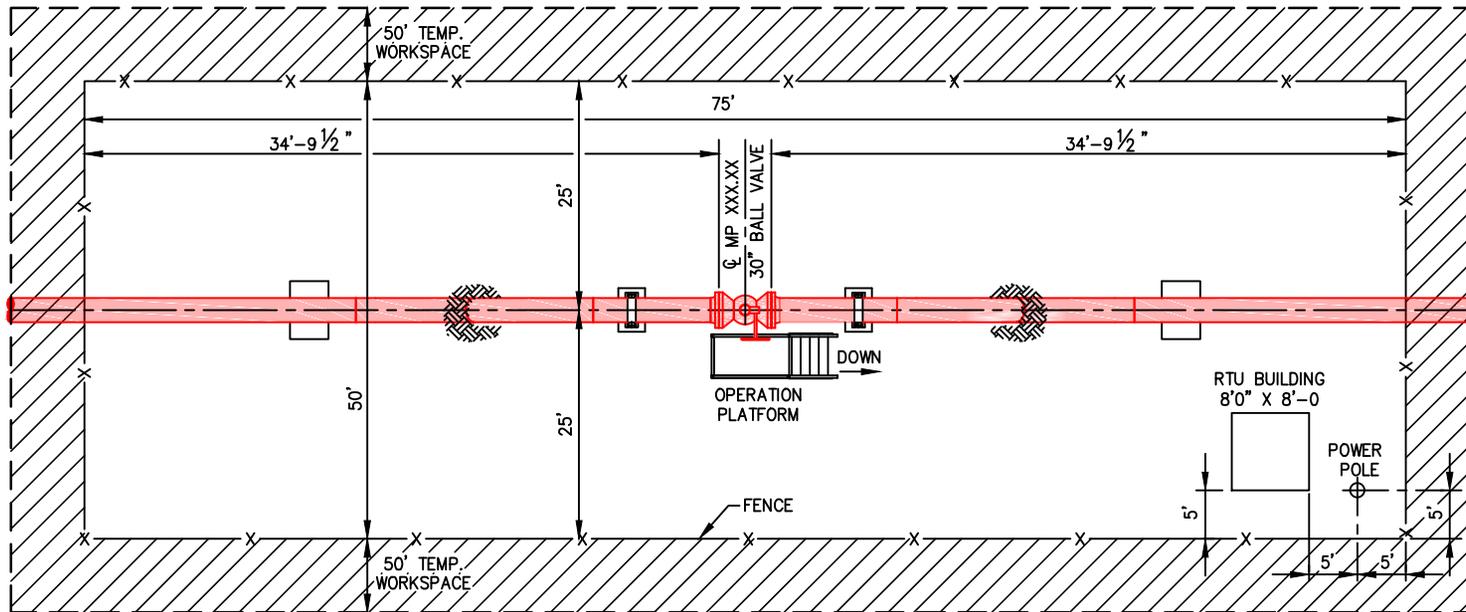

PLAN

N.T.S.

THIS DOCUMENT IS ISSUED FOR INTERIM REVIEW AND IS NOT TO BE USED FOR CONSTRUCTION, BIDDING, OR PERMITTING PURPOSES.

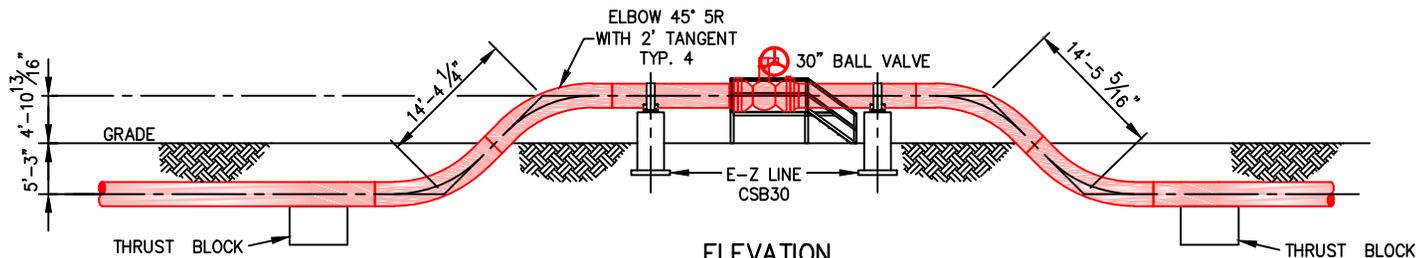

ELEVATION

N.T.S.

REV.	DATE	BY	DESCRIPTION	CHK.
D	10/14/14	JBK	ISSUED FOR APPROVAL	
C	9/15/14	DAH	ISSUED FOR APPROVAL	
B	9/15/14	DAH	ISSUED FOR APPROVAL	
A	9/2/14	DAH	ISSUED FOR REVIEW	

PROJECT NO. 10395700

DAPL/ETCOP

TYPICAL PIPING PLAN AND ELEVATION 30" MAINLINE VALVE PIPELINE

DRAWN BY: DAH	DATE: 9/2/14	DWG. NO.	REV.
CHECKED BY: DAH	DATE: 9/2/14	P12-48	D
SCALE: N.T.S.	APP.:		